




ELEVATION "A"

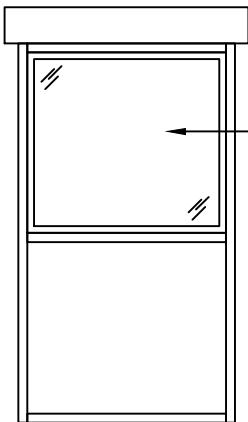


ELEVATION "B"

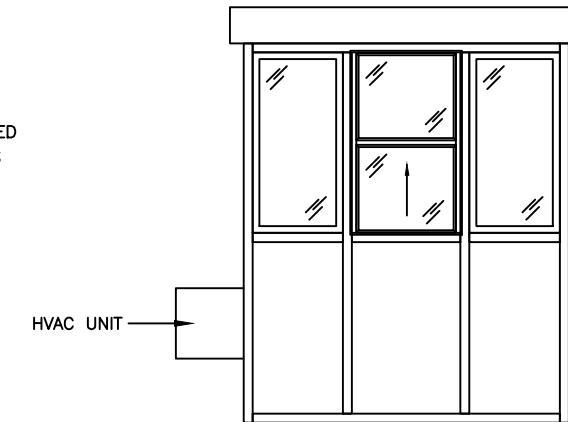


ELEVATION "C"

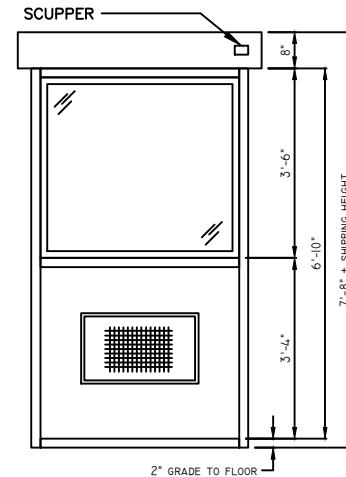


ELEVATION "D"

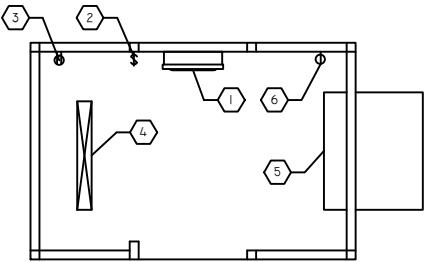

ELECTRICAL PLAN

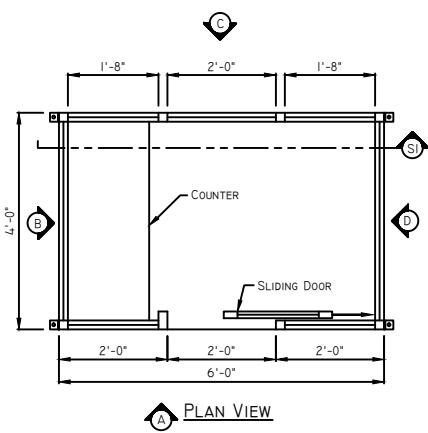


PLAN VIEW

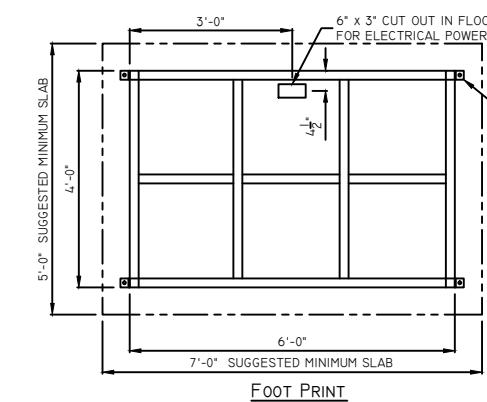

FOOT PRINT

#### ELECTRICAL NOTES

1. 120/240 VOLT, SINGLE PHASE, LOAD CENTER
2. LIGHT SWITCH
3. 120 VOLT, 20 AMP QUAD RECEPTACLE
4. T-8 FLUORESCENT LIGHT FIXTURE WITH TWO - 17 WATT LAMP
5. 240 VOLT, 11,600 BTU COOL/11,200 BTU HEAT HVAC UNIT
6. SINGLE RECEPTACLE 240V/20 AMP FOR HVAC POWER

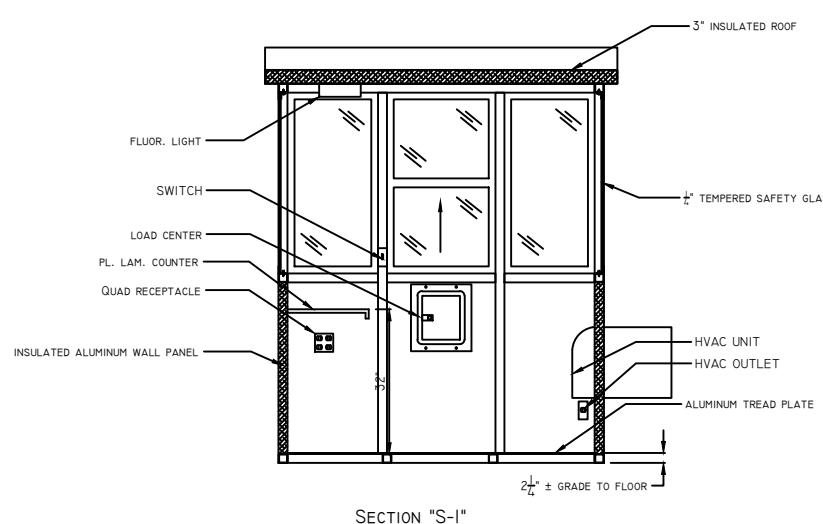

SECTION "S-1"

#### FINISH SCHEDULE

ITEM	DESCRIPTION
FLOOR	ALUMINUM TREADPLATE
INTERIOR WALLS	WHITE
EXTERIOR WALLS	WHITE
EXTERIOR WINDOW FRAMES	WHITE
CANOPY (SOFFIT/FASCIA)	WHITE
CEILING	WHITE
COUNTER	WHITE PLASTIC LAMINATE
GLAZING	CLEAR SAFETY GLAZING

V16-005

MODEL NUMBER MFI-4060-QS	APPROVED BY:
DATE: 6-6-2016	SERIAL NUMBER(S) DRAWN BY: DNE
SCALE: NTS	V16-005 REVISION: .

YACHT COMPANY



MARDAN FABRICATION, INC.  
WWW.MARDANFAB.COM  
800-882-5820

DRAWING SHEET  
SD-1